


SHEET INDEX

ID	NAME
01	COVER
02	CATALOG
03	GENERAL NOTES
04	SITE PLAN
05	PROPOSED FLOOR PLAN
06	PROPOSED FLOOR PLAN 3D
07	FLOOR FINISH PLAN
08	CEILING PLAN
09	POWER OUTLET PLAN
10	LIGHT FIXTURE PLAN
11	FIRE SAFETY DISTANCE PLAN
12	FIRE PROTECTION EQUIPMENTS
13	HVAC RANGE HOOD TYPE 1 POSITION
14	RANGE HOOD TYPE 1 SPECIFICATION
15	HVAC GENERAL NOTES (MECHANICAL DRAWING)
16	PLUMBING FIXTURE PLAN
17	GENERAL NOTES FOR PLUMBING SYSTEM
18	EXISTING TOILET 3D RENDER
19	EXISTING STRUCTURAL DRAWING

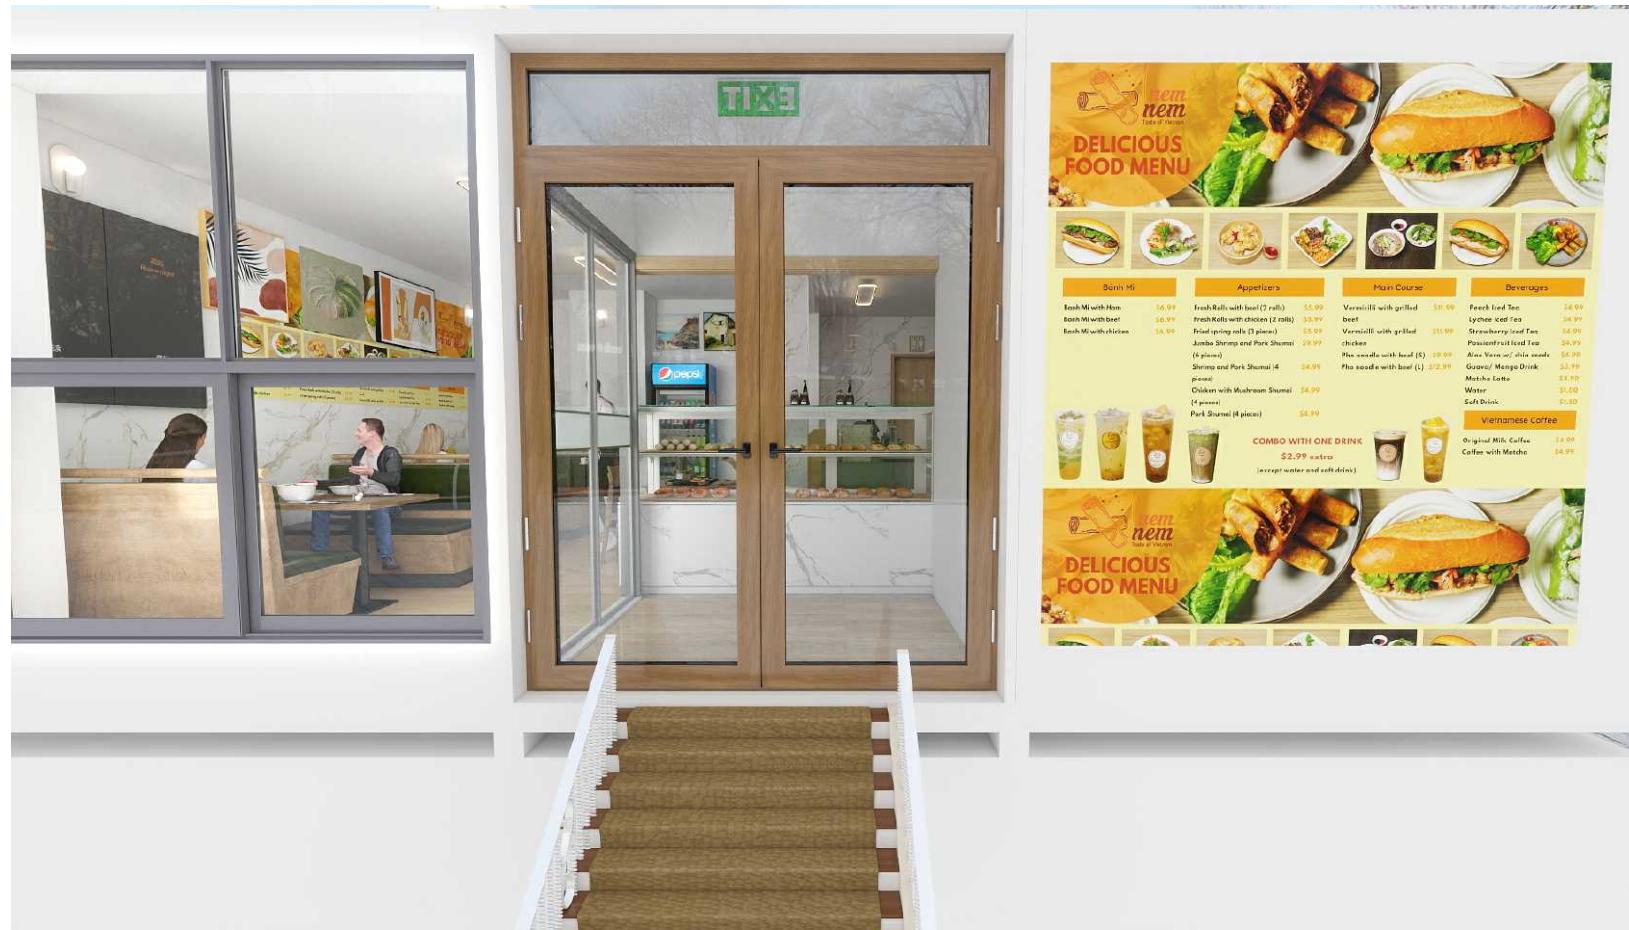

INTERIOR ALTERATION MODEL

555 RITSON ROAD, OSHAWA, ONTARIO

PROJECT ADDRESS:

555 RITSONS,
OSHAWA, ONTARIO

MAP



CONTACTS:

Restaurant Owner: Trang Nguyen
Phone: +1 (647) 210 2068
Email: nemranvietinc@gmail.com

PROJECT DESCRIPTION:

Renovation for Small Restaurant (about 500 sq.ft) that serves mainly for Food TakeOut. The existing structure, facilities is still working well without any alterations

REVISIONS:

SHEET NO.
01

SHEET NAME